

PROJECT: Monteith Elementary

DRAWN BY: C.M.

CHECKED BY: V.T.

FILENAME: CIT\Monteith Elem\Tech As Build


DATE: 04.19.16

SCALE: Full (Model Space)

PLDT Scale To Fit

[illegible]

DRAWING NUMBER:

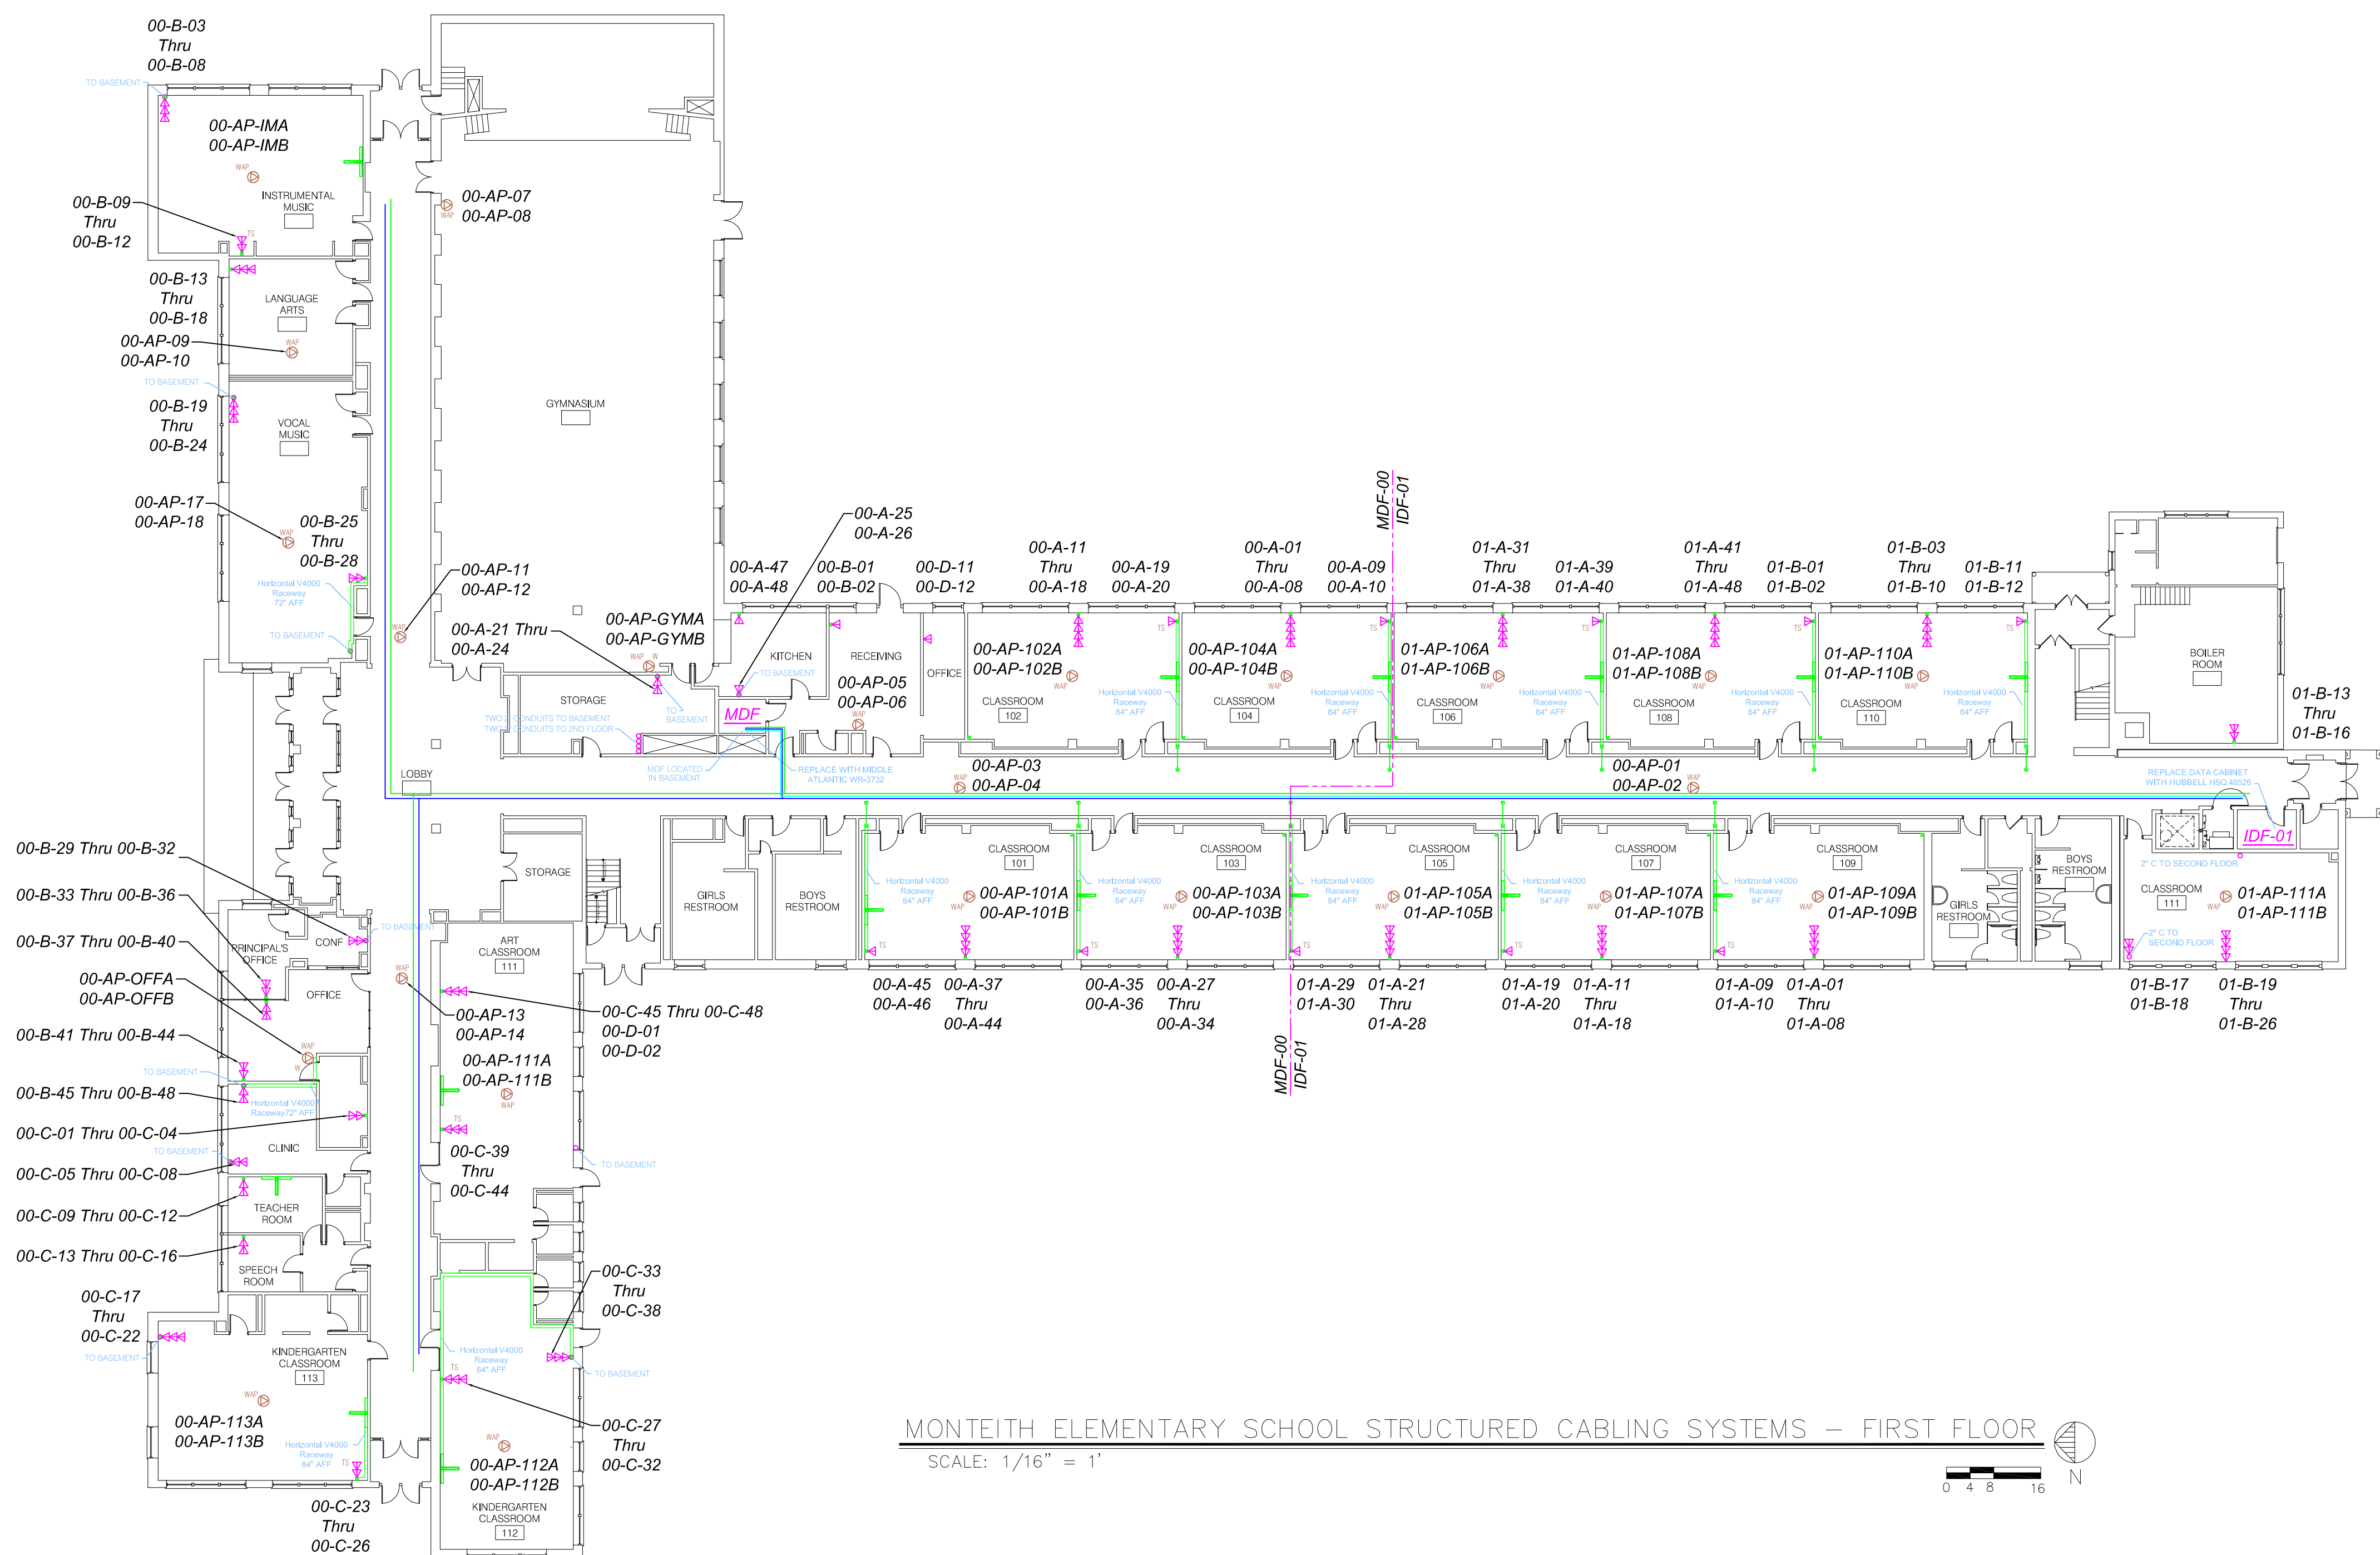

818 West 11 Mile Road
Royal Oak, MI 48067

Tel: (248) 594-5850
Fax: (248) 594-5851
<http://www.wrightshunter.com>


Structured Cabling Systems

Ehresman Associates, Inc.
architects • engineers

Grosse Pointe Public School System
Monteith Elementary School - First Floor
Technology Recabling & Improvements

Project No. 3214

903 West Big Beaver Road, Suite 350, Troy, Michigan 48064 • 248.244.9710 • (f) 248.244.9712
email: architects@ehresmanassociates.com
© Ehresman Associates, Inc. 2013

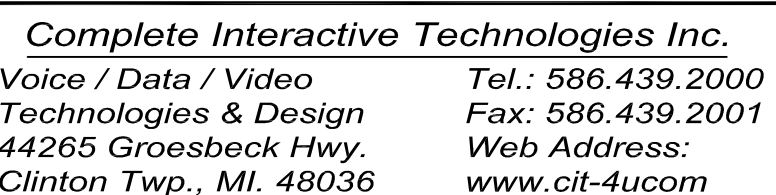

PROJECT: Monteith Elementary

DRAWN BY: C.M.

CHECKED BY: V.T.

FILENAME: CIT\Monteith Elem\Tech As Build

DATE: 04.19.16


SCALE: Full (Model Space)

SCALE: Scale To Fit

[illegible]

DRAWING NUMBER:

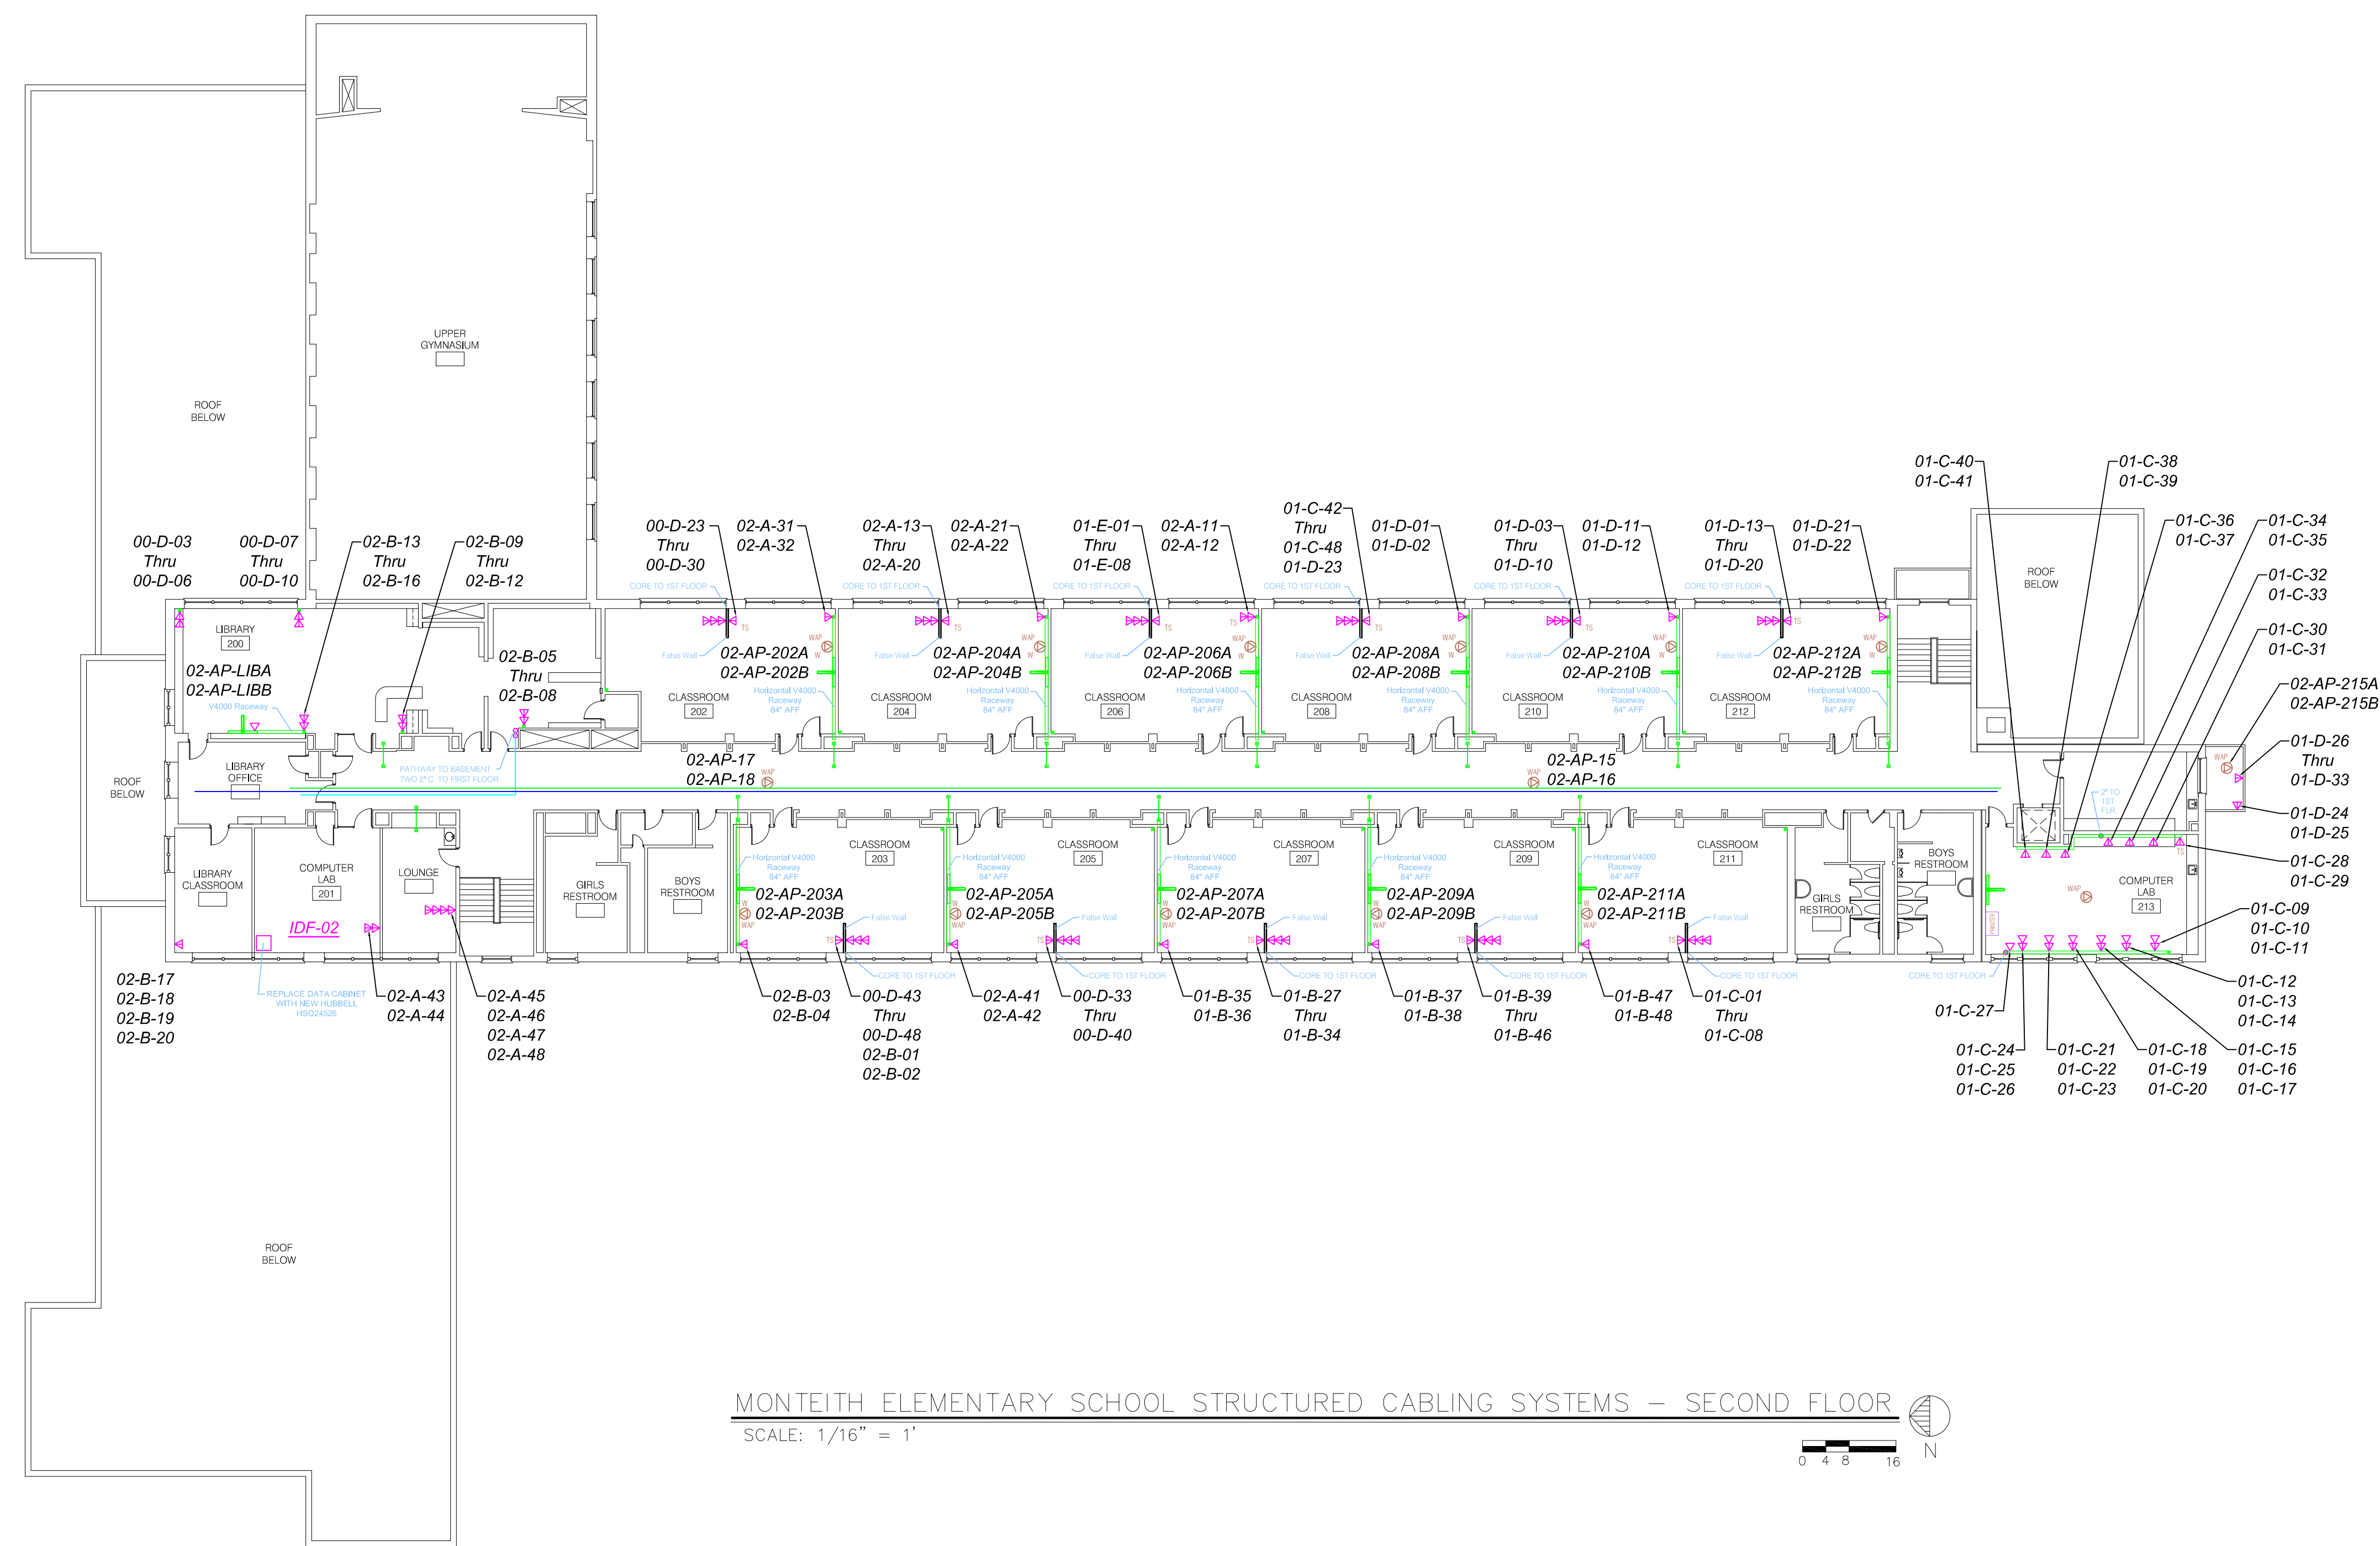

Innovative & Independent
TECHNOLOGY ADVISORS

818 West 11 Mile Road
Royal Oak, MI 48067

Tel: (248) 594-5850
Fax: (248) 594-5851
<http://www.wrighthunter.com>

Structured Cabling Systems


Ehresman Associates, Inc.
architects • engineers

Grosse Pointe Public School System
Monteith Elementary School - Second Floor
Technology Recabling & Improvements

Project No. 3214

T 2.2C

803 West Big Beaver Road, Suite 350, Troy, Michigan 48064 • 248.244.9710 • (f) 248.244.9712
email: architects@ehresmanassociates.com
© Ehresman Associates, Inc. 2013

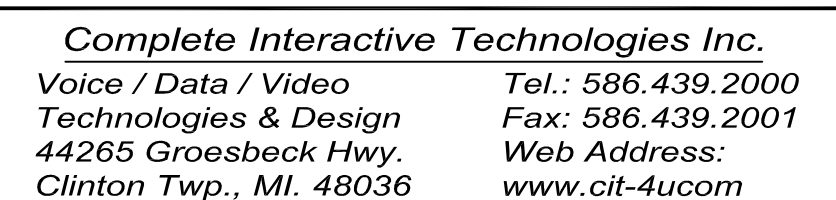

PROJECT: South High School

DESCRIPTION: Technology Recabling &

Improvements - As Build

DRAWN BY: V.T.

CHECKED BY: S.W.

FILENAME: C:\South HS\Tech As Build

DATE: 06.06.16


SCALE: Full (Mode|Space)

PLDT Scale To Fit.

[illegible]

DRAWING NUMBER:

—

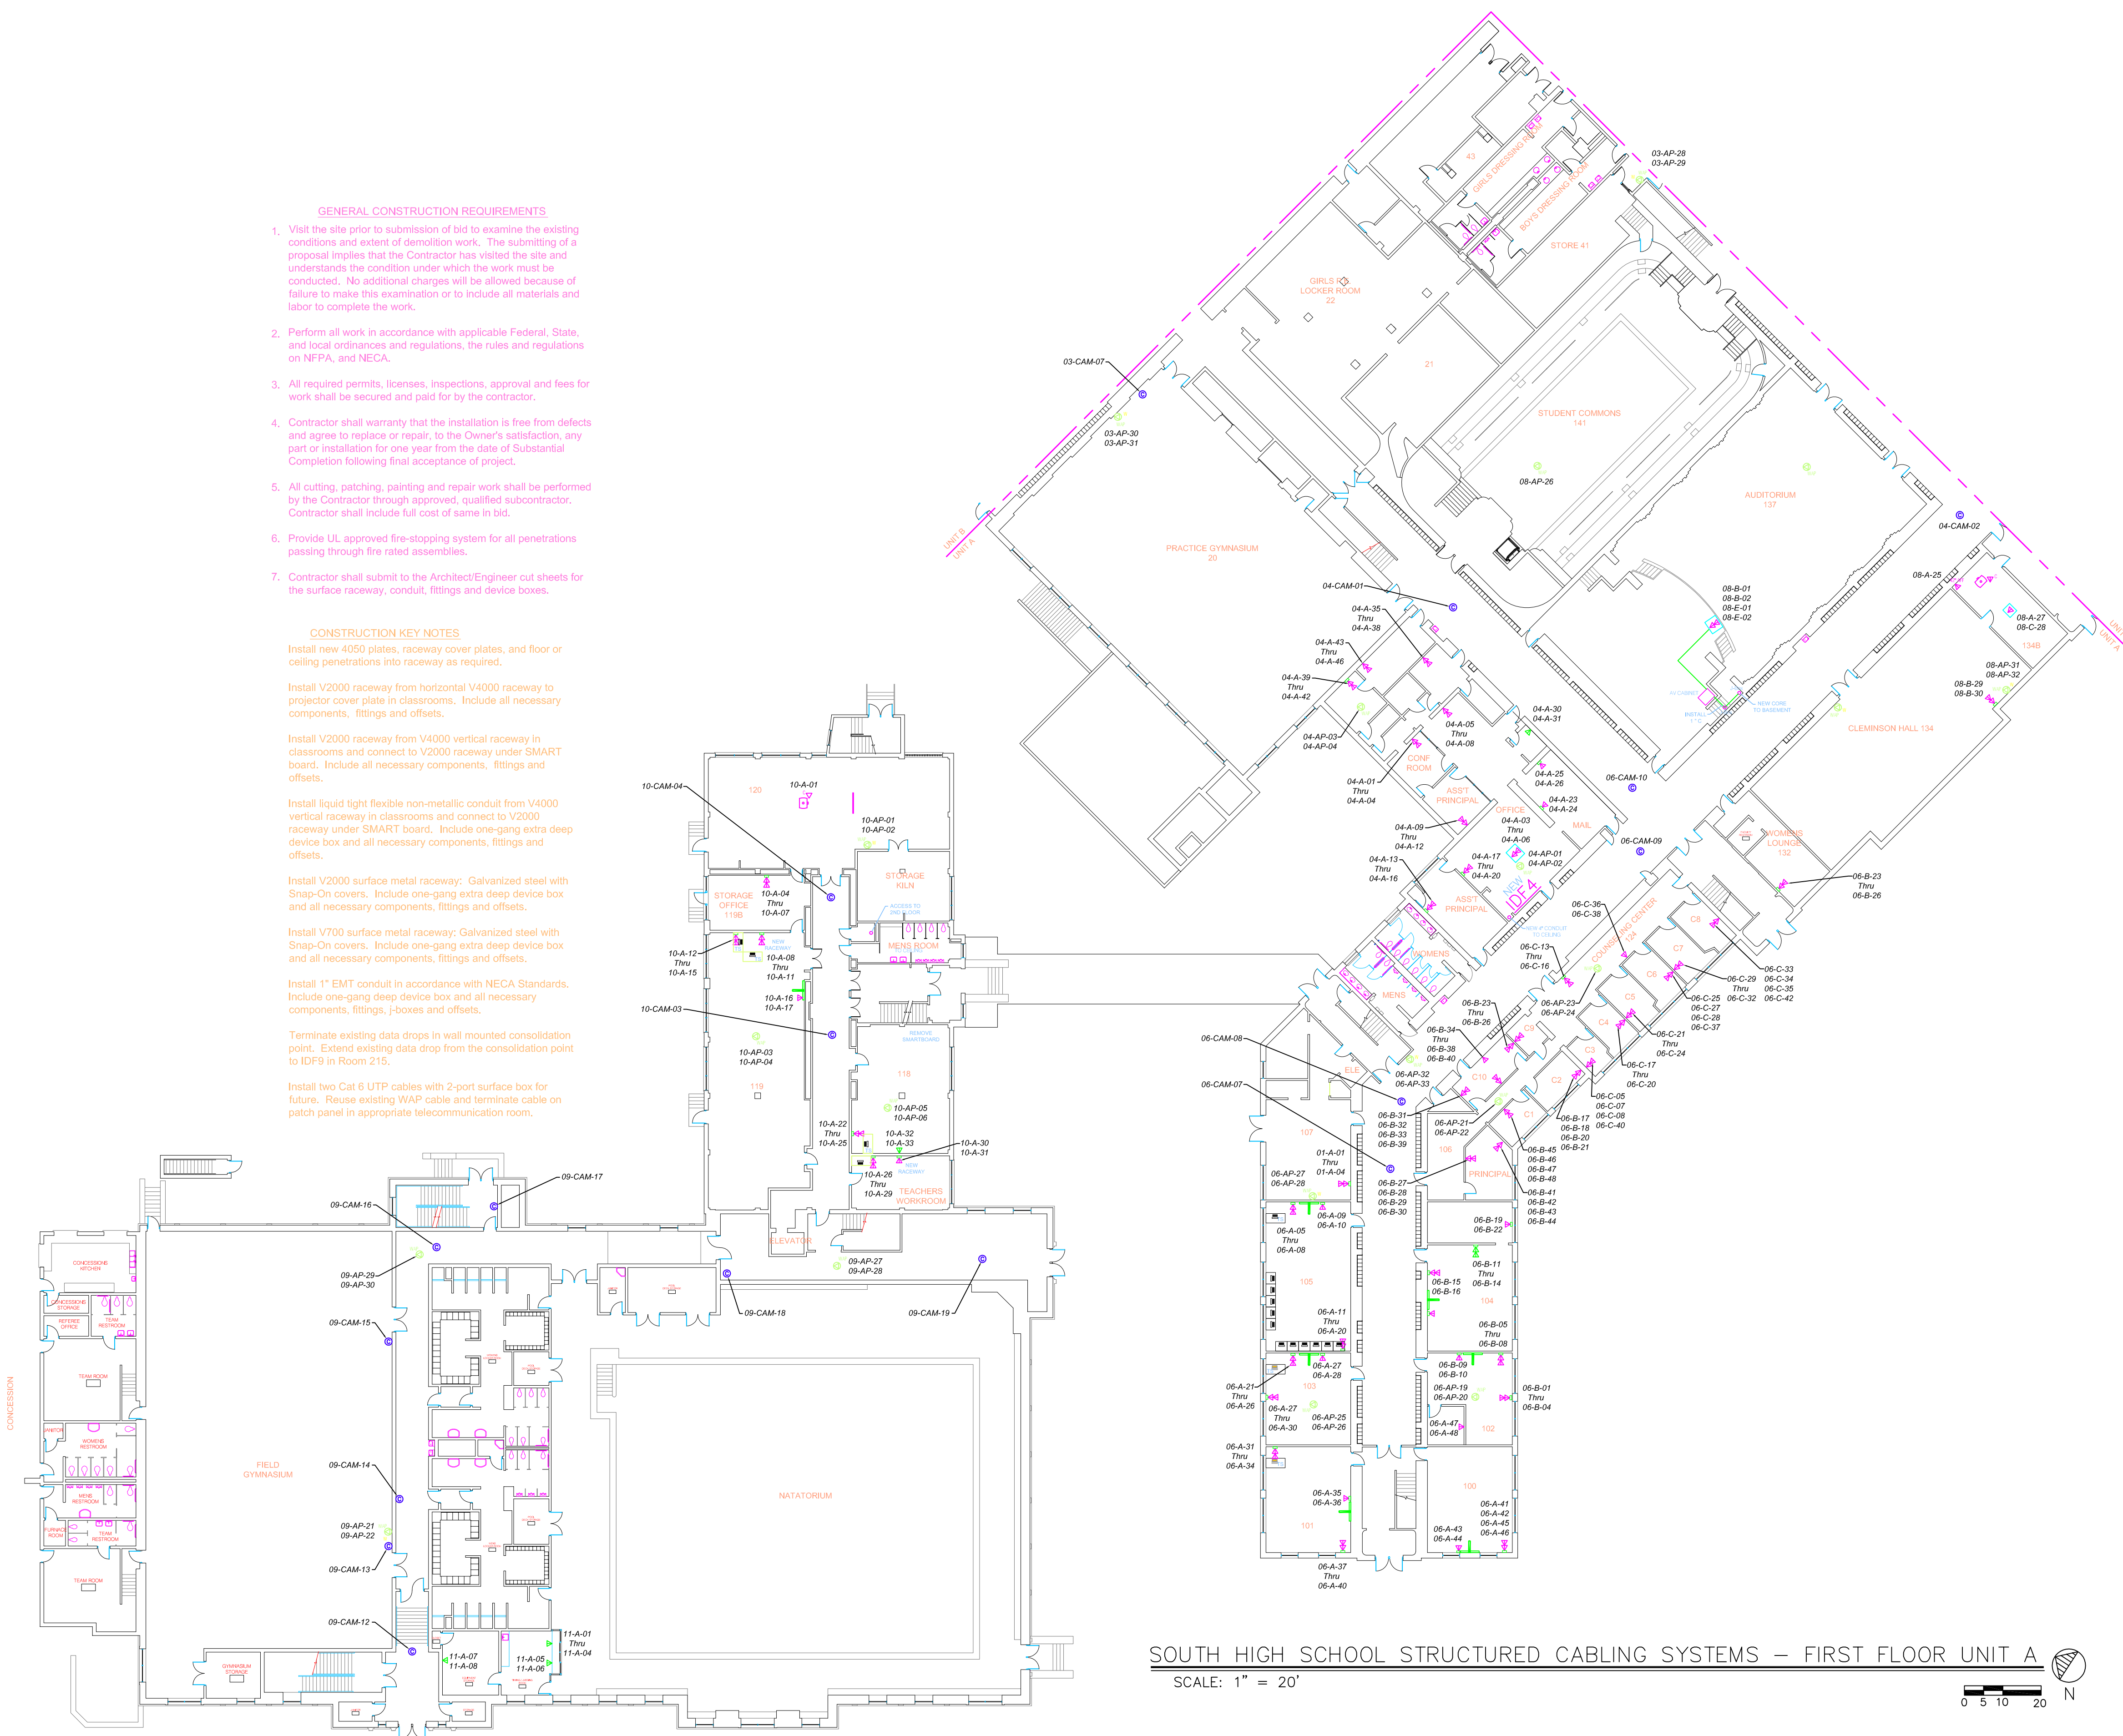The logo for Wright & Hunter, featuring a stylized 'W' and 'H' with an ampersand in a circle, above the words 'WRIGHT' and 'HUNTER' in a bold, sans-serif font.

Bidding: 13 January 2015

Structured Cabling Systems

Ehresman Associates, Inc.

architects • engineers

Grosse Pointe Public School System
South High School - First Floor Unit A
Technology Recabling & Improvements

Project No. 3114

803 West Big Beaver Road, Suite 350, Troy, Michigan 48064 • 248.244.9710 • (F) 248.244.9712
email: architects@ehresmanassociates.com
© Ehresman Associates, Inc. 2013


T 2.2H



PLOT SCALE: Scale To Fit

[illegible][illegible]

7

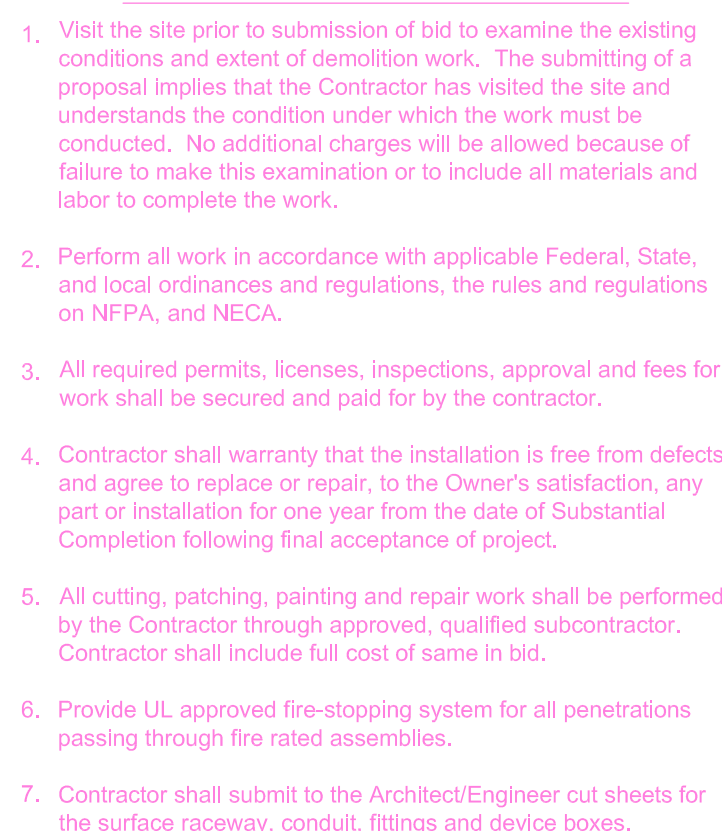


UNIT B

0 5 10 20

N

T 2.3H

803 West Big Beaver Road, Suite 350, Troy, Michigan 48064 • 248.244.9710 • (f) 248.244.9712
email: architects@ehresmanassociates.com
© Ehresman Associates, Inc. 2013

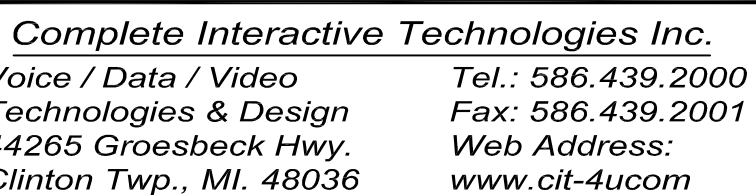


DESCRIPTION: Technology Recabling &
Improvements - As Build

LOT SCALE: Scale To Fit

[illegible]

Case	Age	Sex	Occupation	Duration of symptoms (years)	Onset	Course	Family history	Social history	Physical examination	Laboratory studies	Imaging studies	Pathology	Treatment	Outcome
1	45	M	Teacher	10	1985	Chronic	None	None	Normal	Normal	Normal	Normal	None	Stable
2	52	F	Homemaker	5	1990	Chronic	None	None	Normal	Normal	Normal	Normal	None	Stable
3	68	M	Retired	15	1975	Chronic	None	None	Normal	Normal	Normal	Normal	None	Stable
4	35	F	Nurse	8	1988	Chronic	None	None	Normal	Normal	Normal	Normal	None	Stable
5	42	M	Engineer	12	1980	Chronic	None	None	Normal	Normal	Normal	Normal	None	Stable
6	58	F	Homemaker	7	1992	Chronic	None	None	Normal	Normal	Normal	Normal	None	Stable
7	65	M	Retired	18	1970	Chronic	None	None	Normal	Normal	Normal	Normal	None	Stable
8	38	F	Teacher	6	1995	Chronic	None	None	Normal	Normal	Normal	Normal	None	Stable
9	55	M	Engineer	9	1987	Chronic	None	None	Normal	Normal	Normal	Normal	None	Stable
10	48	F	Homemaker	11	1983	Chronic	None	None	Normal	Normal	Normal	Normal	None	Stable
11	62	M	Retired	14	1978	Chronic	None	None	Normal	Normal	Normal	Normal	None	Stable
12	32	F	Nurse	4	1998	Chronic	None	None	Normal	Normal	Normal	Normal	None	Stable
13	50	M	Engineer	10	1986	Chronic	None	None	Normal	Normal	Normal	Normal	None	Stable
14	57	F	Homemaker	8	1991	Chronic	None	None	Normal	Normal	Normal	Normal	None	Stable
15	63	M	Retired	16	1972	Chronic	None	None	Normal	Normal	Normal	Normal	None	Stable
16	37	F	Teacher	5	1996	Chronic	None	None	Normal	Normal	Normal	Normal	None	Stable
17	53	M	Engineer	9	1989	Chronic	None	None	Normal	Normal	Normal	Normal	None	Stable
18	49	F	Homemaker	11	1984	Chronic	None	None	Normal	Normal	Normal	Normal	None	Stable
19	61	M	Retired	13	1979	Chronic	None	None	Normal	Normal	Normal	Normal	None	Stable
20	34	F	Nurse	3	1999	Chronic	None	None	Normal	Normal	Normal	Normal	None	Stable
21	51	M	Engineer	10	1987	Chronic	None	None	Normal	Normal	Normal	Normal	None	Stable
22	56	F	Homemaker	8	1993	Chronic	None	None	Normal	Normal	Normal	Normal	None	Stable
23	64	M	Retired	17	1971	Chronic	None	None	Normal	Normal	Normal	Normal	None	Stable
24	36	F	Teacher	4	1997	Chronic	None	None	Normal	Normal	Normal	Normal	None	Stable
25	54	M	Engineer	9	1990	Chronic	None	None	Normal	Normal	Normal	Normal	None	Stable
26	47	F	Homemaker	11	1985	Chronic	None	None	Normal	Normal	Normal	Normal	None	Stable
27	60	M	Retired	14	1977	Chronic	None	None	Normal	Normal	Normal	Normal	None	Stable
28	33	F	Nurse	3	2000	Chronic	None	None	Normal	Normal	Normal	Normal	None	Stable
29	52	M	Engineer	10	1988	Chronic	None	None	Normal	Normal	Normal	Normal	None	Stable
30	59	F	Homemaker	7	1994	Chronic	None	None	Normal	Normal	Normal	Normal	None	Stable
31	66	M	Retired	19	1973	Chronic	None	None	Normal	Normal	Normal	Normal	None	Stable
32	39	F	Teacher	5	1999	Chronic	None	None	Normal	Normal	Normal	Normal	None	Stable
33	53	M	Engineer	9	1991	Chronic	None	None	Normal	Normal	Normal	Normal	None	Stable
34	46	F	Homemaker	11	1986	Chronic	None	None	Normal	Normal	Normal	Normal	None	Stable
35	62	M	Retired	15	1976	Chronic	None	None	Normal	Normal	Normal	Normal	None	Stable
36	31	F	Nurse	4	2001	Chronic	None	None	Normal	Normal				

4

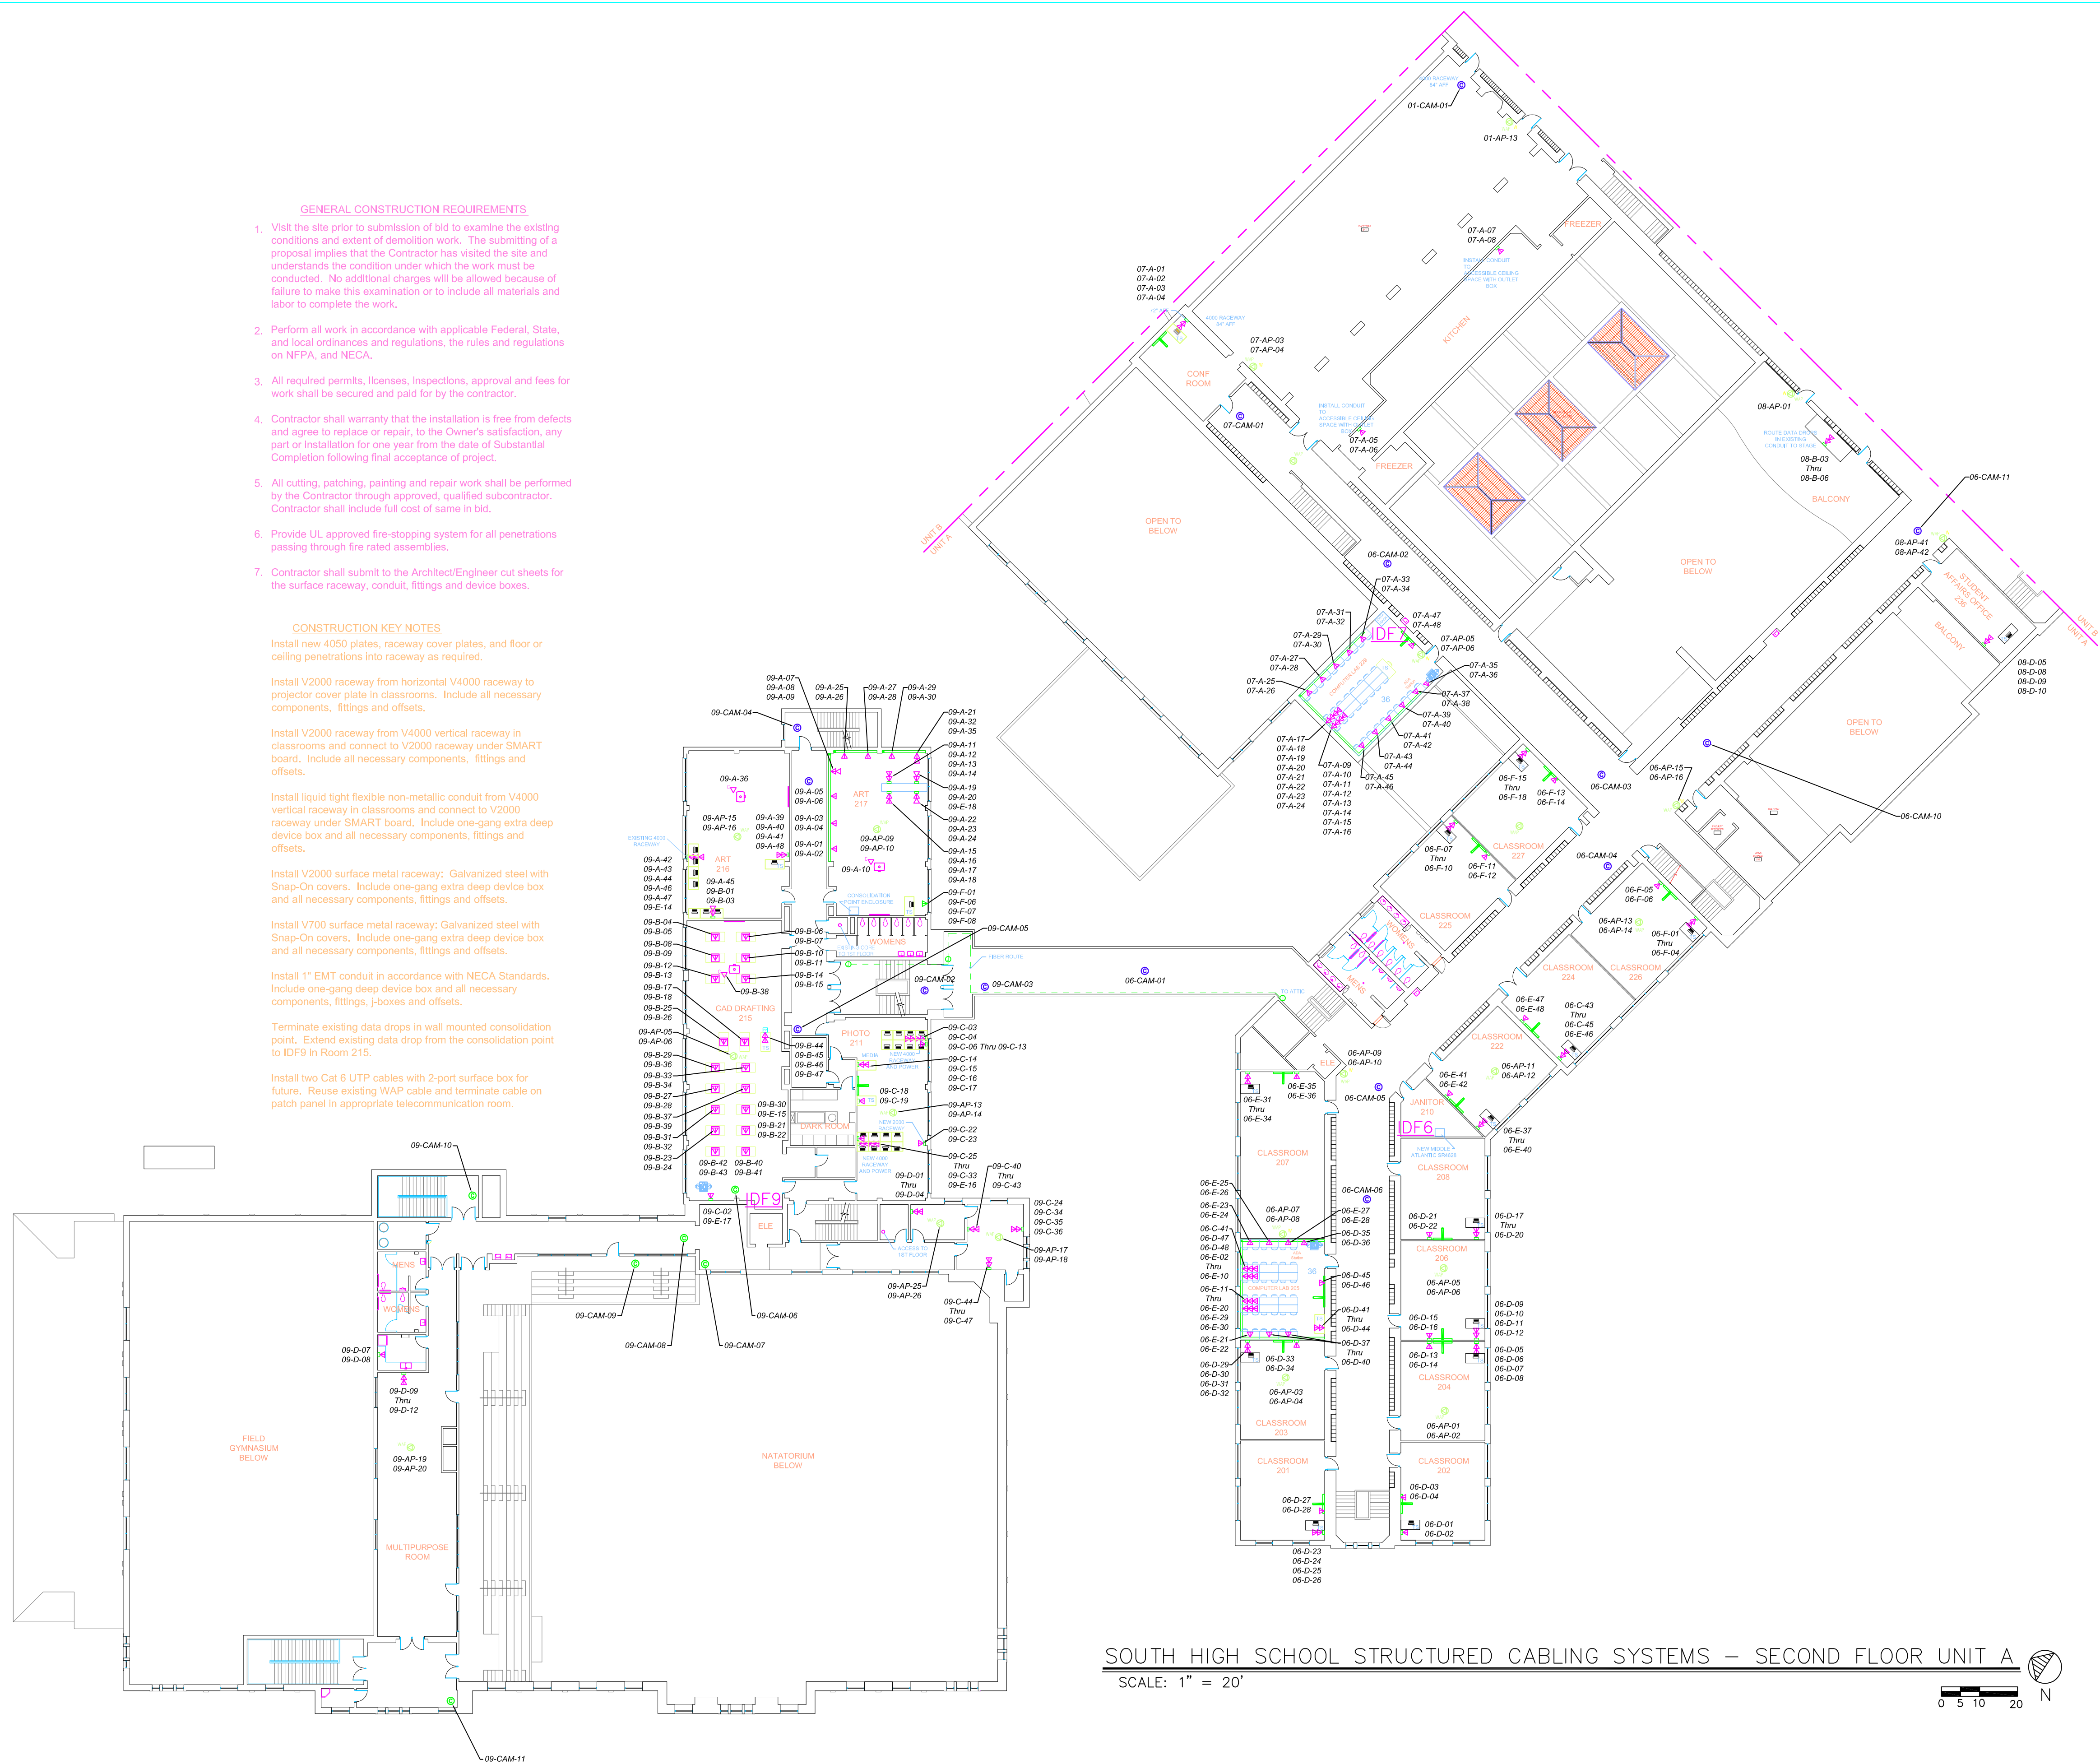

Bidding: 13 January 2015

Structured Cabling Systems

Ehresman Associates, Inc.


architects • engineers

Grosse Pointe Public School System
South High School - Second Floor Unit A
Technology Recabling & Improvements

Project No. 3114

T 2.4H

803 West Big Beaver Road, Suite 350, Troy, Michigan 48064 • 248.244.9710 • (f) 248.244.9712
email: architects@ehresmanassociates.com
© Ehresman Associates, Inc. 2013

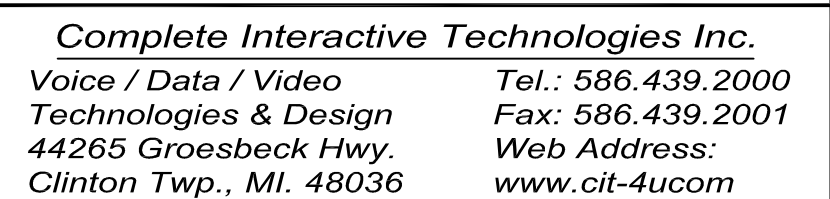

PROJECT: South High School

DRAWN BY: V.T.

CHECKED BY: S.W

FILENAME: C:\South HS\Tech As Build

DATE: 06.16.16

SCALE: Full (Model Space)

PLOT SCALE: Scale To Fit

[illegible]

--	--

5



Bidding: 13 January 2015

Structured Cabling Systems

Ehresman Associates, Inc.

architects • engineers

Grosse Pointe Public School System
South High School - Second Floor Unit B
Technology Recabling & Improvements


Project No. 3114

803 West Big Beaver Road, Suite 350, Troy, Michigan 48064 • 248.244.9710 • (f) 248.244.9712
email: architects@ehresmanassociates.com
© Ehresman Associates, Inc. 2013

SOUTH HIGH SCHOOL STRUCTURED CABLING SYSTEMS – SECOND FLOOR UNIT B

SCALE: 1" = 20'



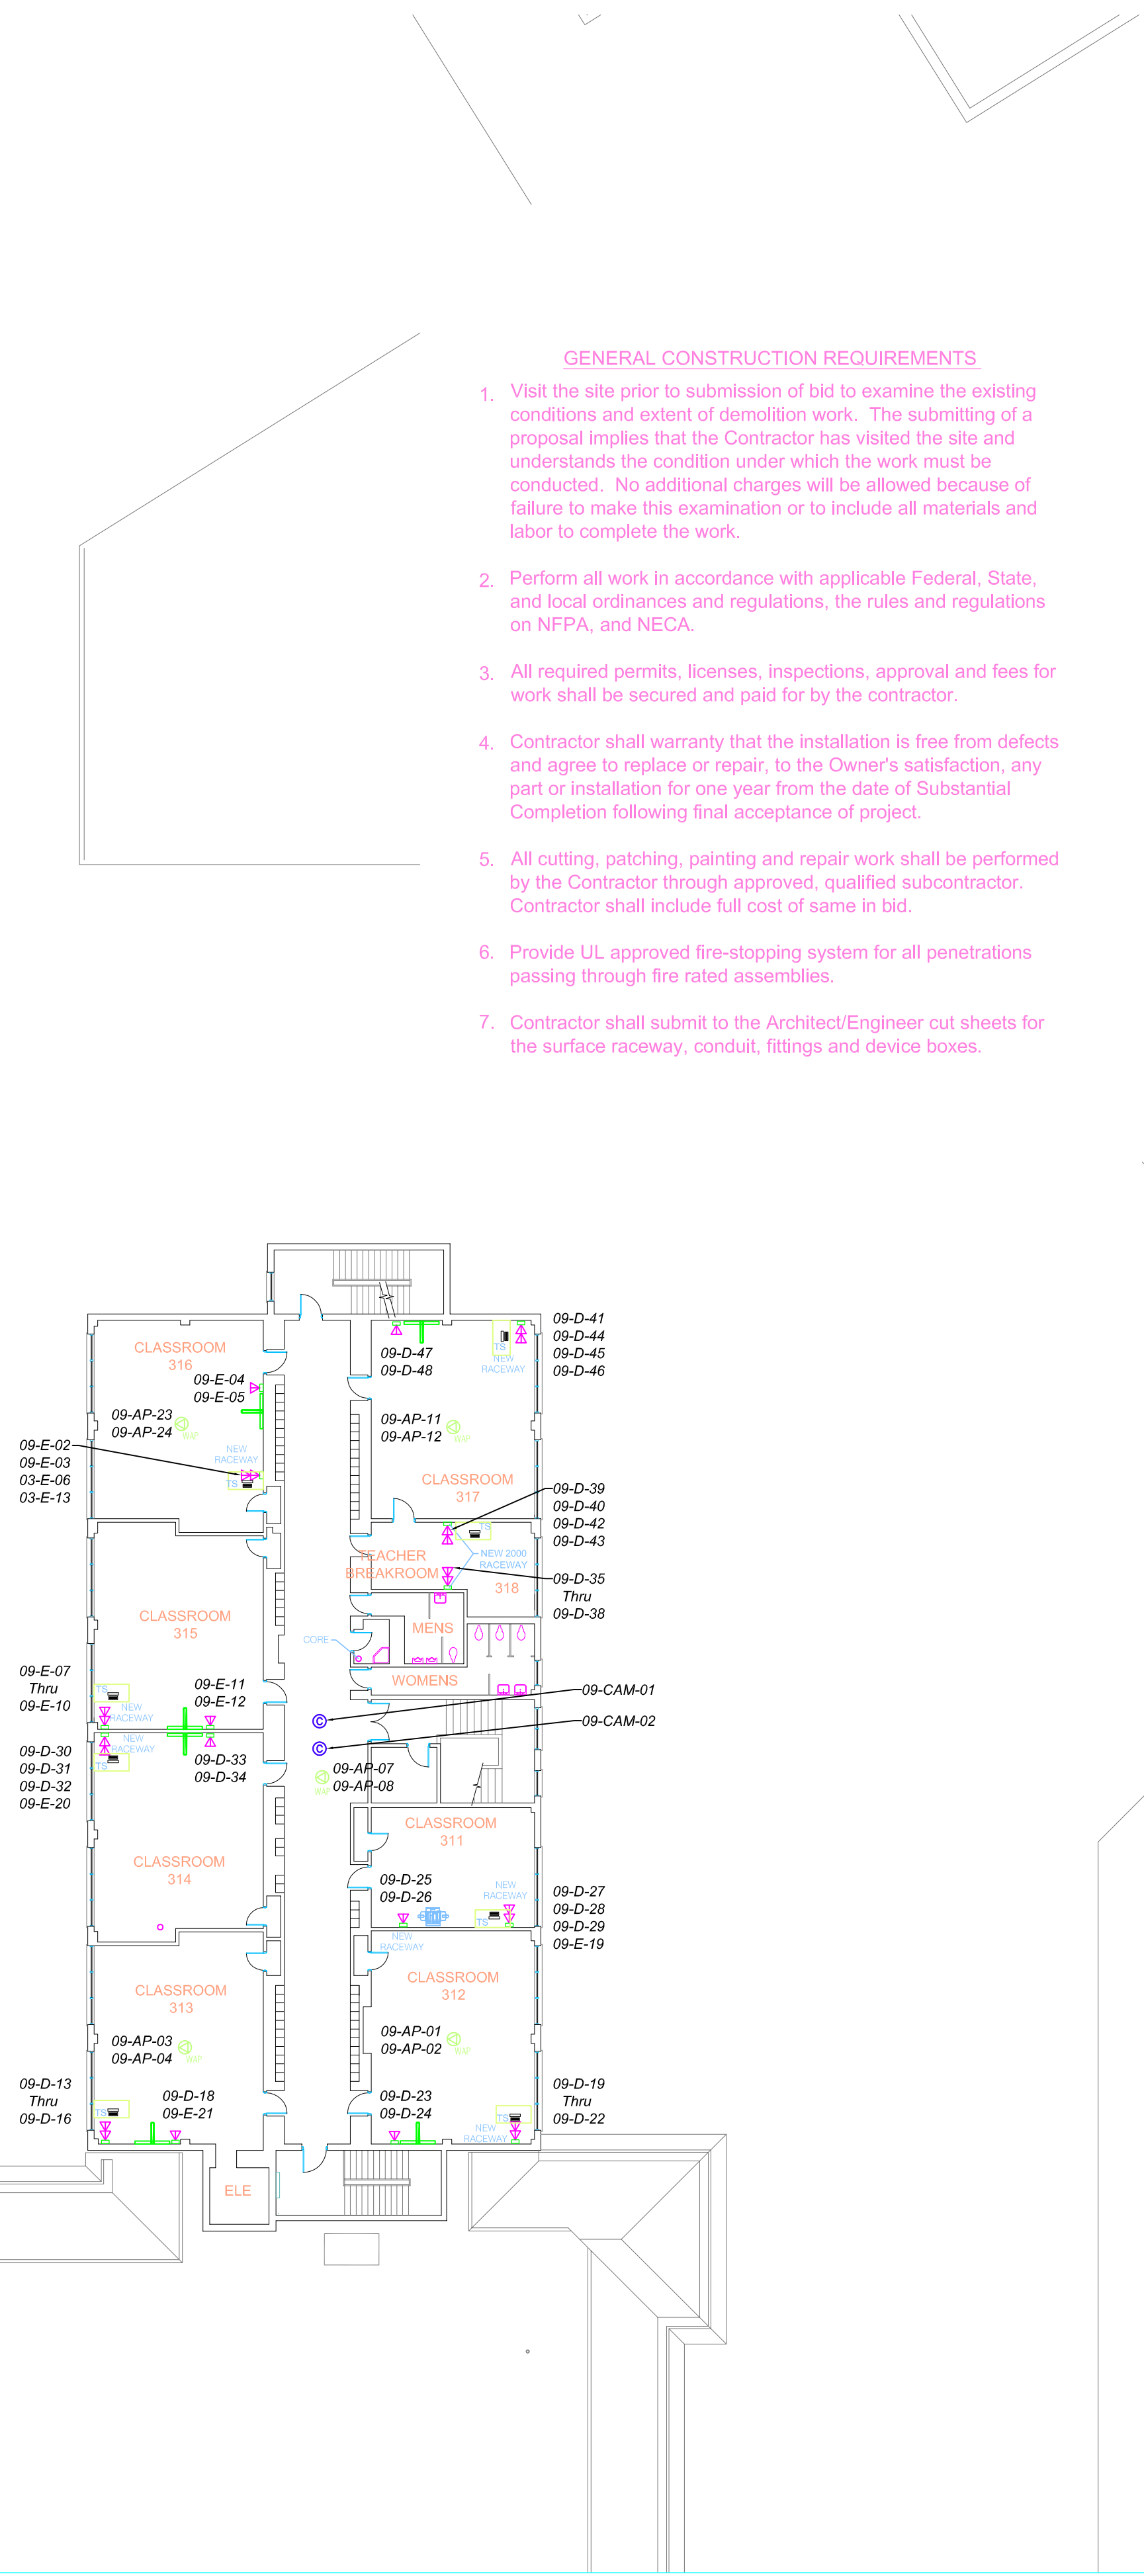

CONSTRUCTION KEY NOTES

Install new 4050 plates, raceway cover plates, and floor or ceiling penetrations into raceway as required.

Install V2000 raceway from horizontal V4000 raceway to projector cover plate in classrooms. Include all necessary components, fittings and offsets.

Install V2000 raceway from V4000 vertical raceway in classrooms and connect to V2000 raceway under SMART board. Include all necessary components, fittings and offsets.

Install liquid tight flexible non-metallic conduit from V4000 vertical raceway in classrooms and connect to V2000 raceway under SMART board. Include one-gang extra deep device box and all necessary components, fittings and offsets.

Install V2000 surface metal raceway: Galvanized steel with Snap-On covers. Include one-gang extra deep device box and all necessary components, fittings and offsets.

Install V700 surface metal raceway: Galvanized steel with Snap-On covers. Include one-gang extra deep device box and all necessary components, fittings and offsets.

Install 1" EMT conduit in accordance with NECA Standards. Include one-gang extra deep device box and all necessary components, fittings, j-boxes and offsets.

Terminate existing data drops in wall mounted consolidation point. Extend existing data drop from the consolidation point to IDF9 in Room 215.

Install two Cat 6 UTP cables with 2-port surface box for future. Reuse existing WAP cable and terminate cable on patch panel in appropriate telecommunication room.

SOUTH HIGH SCHOOL STRUCTURED CABLING SYSTEMS – THIRD FLOOR
SCALE: 1/16" = 1'

W&H
WRIGHT HUNTER
Innovative & Independent
TECHNOLOGY ADVISORS
818 West 11 Mile Road
Royal Oak, MI 48067
Tel: (248) 594-5850
Fax: (248) 594-5851
<http://www.wrighthunter.com>

Bidding: 13 January 2015
Structured Cabling Systems
Ehresman Associates, Inc.
architects • engineers
Grosse Pointe Public School System
South High School - Third Floor
Technology Recabling & Improvements
Project No. 3114
803 West Big Beaver Road, Suite 350, Troy, Michigan 48064 • 248.244.9710 • (P) 248.244.9712
email: architects@ehresmanassociates.com
© Ehresman Associates, Inc. 2013




Complete Interactive Technologies Inc.
Voice / Data / Video
Technologies & Design
44265 Groesbeck Hwy.
Clinton Twp., MI. 48036
Tel.: 586.439.2000
Fax: 586.439.2001
Web Address:
www.cit-4u.com

CLIENT: Grosse Pointe Public School System
PROJECT: South High School
DESCRIPTION: Technology Recabling & Improvements - As Build
DRAWN BY: V.T.
CHECKED BY: S.W.
FILENAME: CIT\South HS\Tech As Build
DATE: 06.16.16
SCALE: Full (Model Space)
PLOT SCALE: Scale To Fit

REVISIONS		
REVISION DATE	DESCRIPTION	APPROVED BY

NOTES

DRAWING NUMBER:

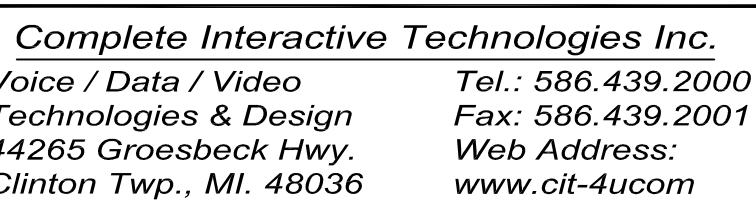

PROJECT: South High School

DESCRIPTION: Technology Recabling &

Improvements - As Built

DRAWN BY: V.T

CHECKED BY: S.W.

FILENAME: C:\South HS\Tech As Build

DATE: 06.16.16

SCALE: Full (Model Space)

PLOT SCALE: Scale To Fit

[illegible]

--

DRAWING NUMBER:



Bidding: 13 January 2015

Structured Cabling Systems

Ehresman Associates, Inc.

architects • engineers

Grosse Pointe Public School System
South High School - Basement
Technology Recabling & Improvements

Project No. 3114

T 2.1H

803 West Big Beaver Road, Suite 350, Troy, Michigan 48064 • 248.244.9710 • (f) 248.244.9712
email: architects@ehresmanassociates.com
© Ehresman Associates, Inc. 2013

